


ENCODER HEAD

H7 PLUG

- | | | | | | | | |
|---|---|---|---|---|---|---|---|
| 1 | 2 | 3 | 4 | 5 | 6 | 7 | 8 |
|---|---|---|---|---|---|---|---|

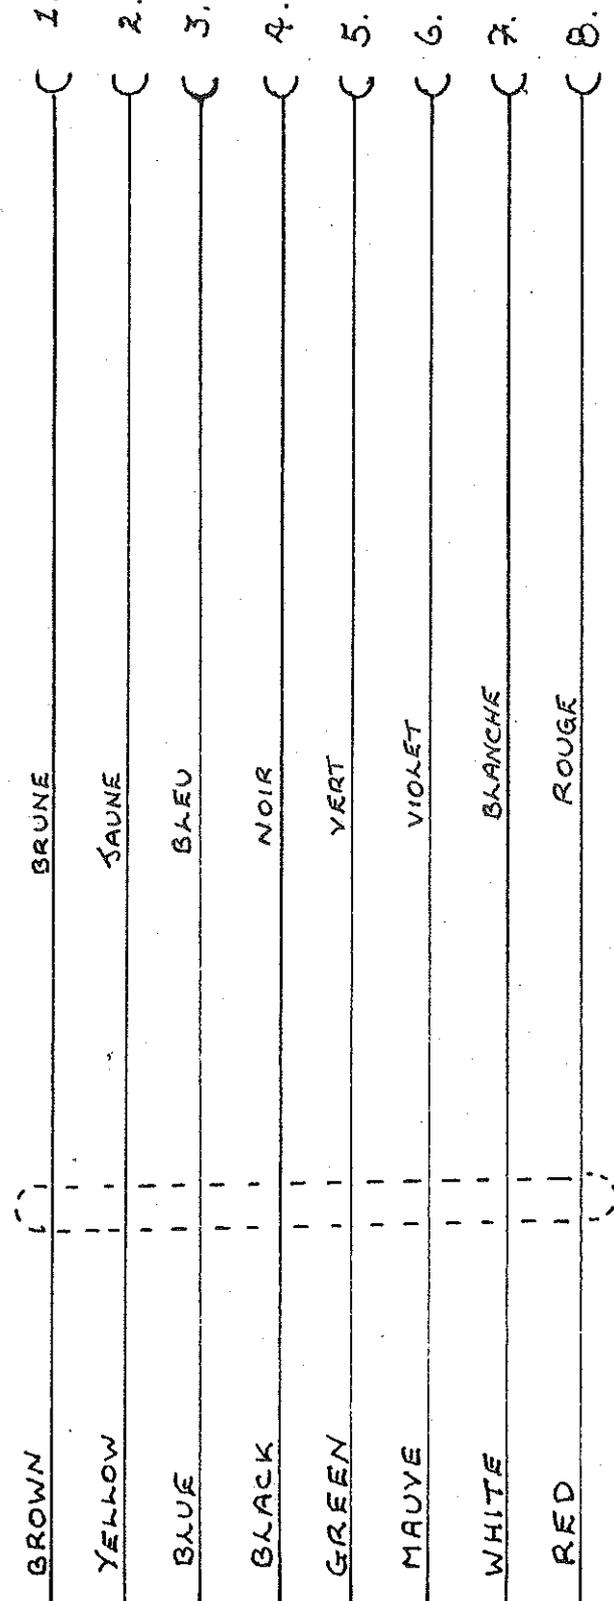

= FILTERER.



REVS

MICA MACHINERY (SALES) LTD
MICA HOUSE DENTON, MANCHESTER
TEL: 061 320 3356 FAX: 061 320 3345

LINEAR ENCODER
TYPE GEL 220

SCALE MTS
DATE 3 - 3 - 92
DRG No A92 - 71

CTM1

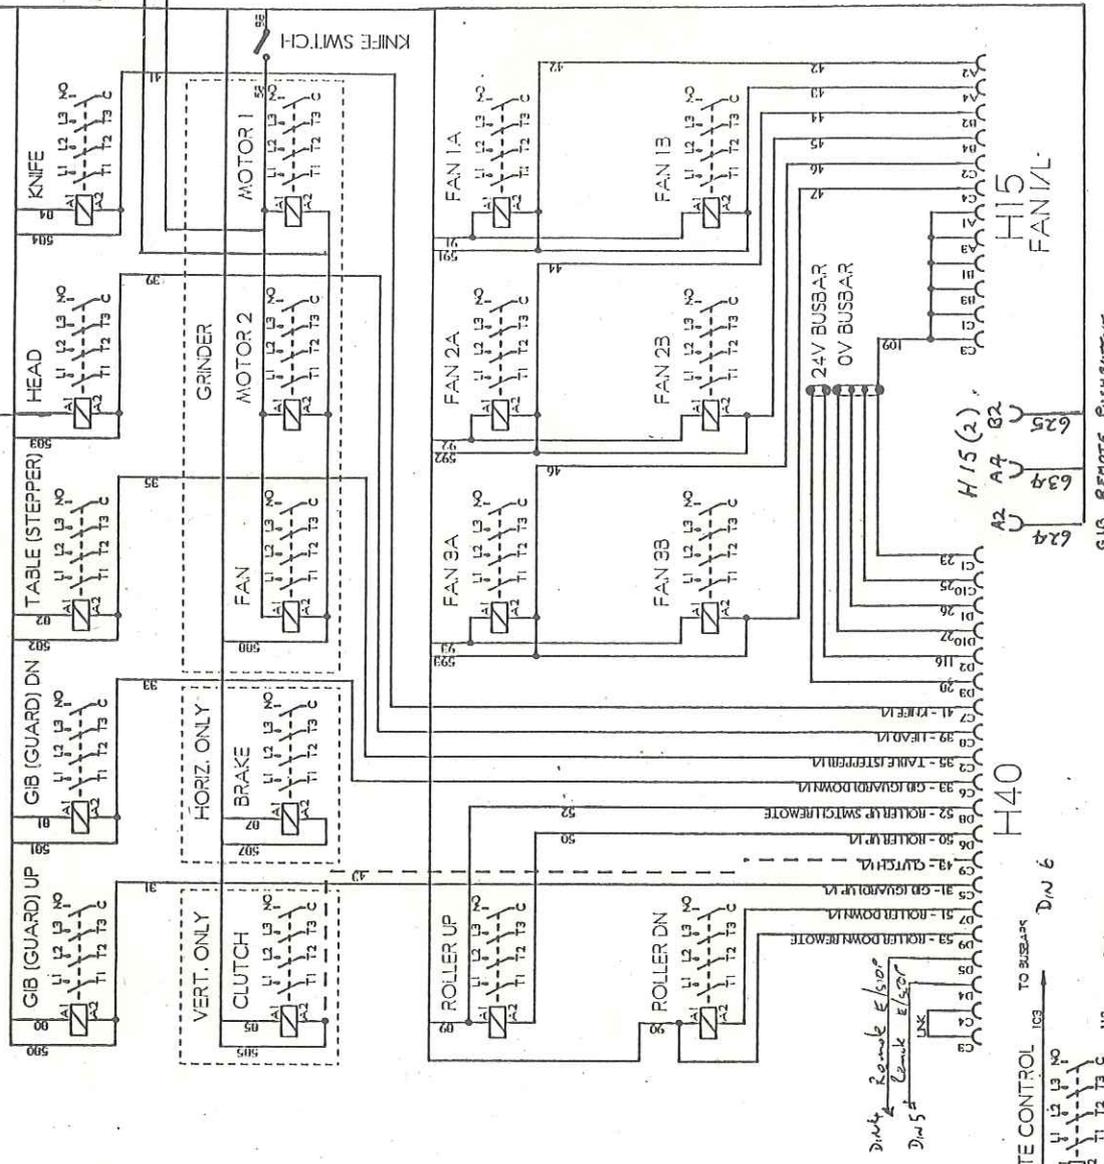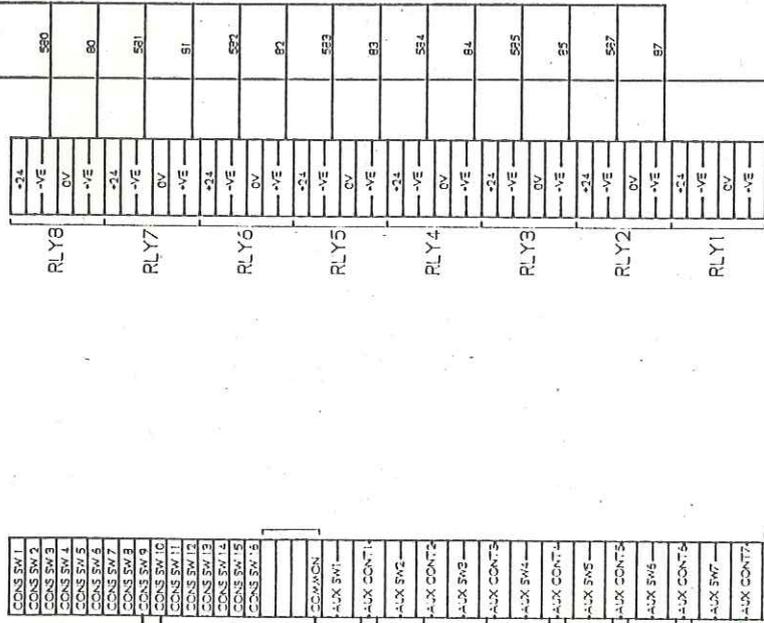

REVS


MICA MACHINERY (SALES) LTD
MICA HOUSE DENTON MANCHESTER
TEL: 061 320 3356 FAX: 061 320 3345

SCALE NTS
DATE 3-3-92
DRG No B 92-70


COIL & INTERLOCK CIRCUIT SKITTERS. O2

FAN 1 }
FAN 2 }
A1 FAN 3 }
A2 FAN 3 }
FAN 4


CONSOLE SWITCHES

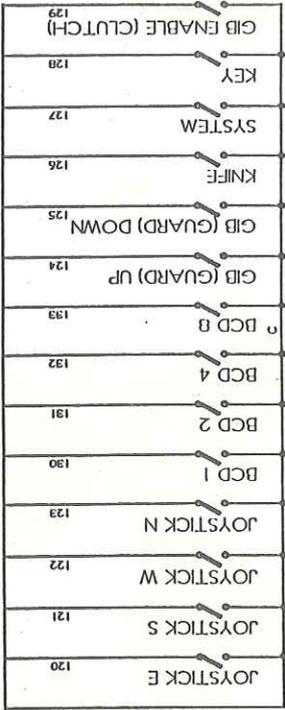


KEYPAD SWITCHES

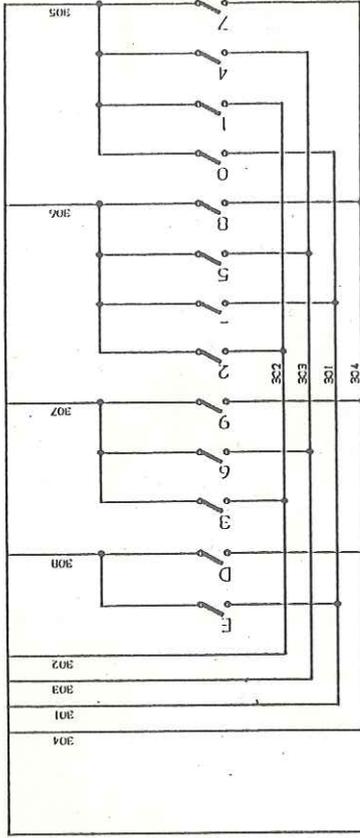


AUXILIARY CONSOLE SWITCHES

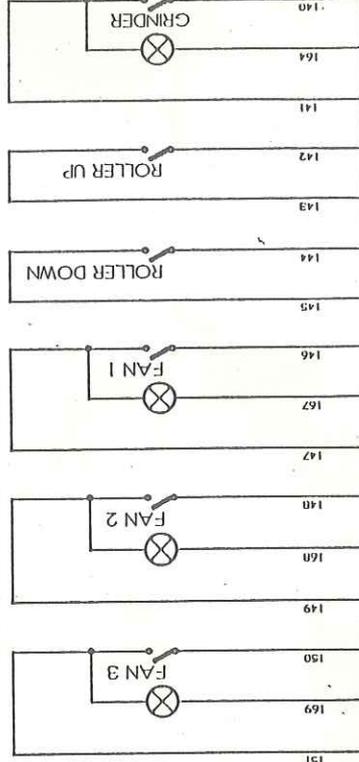

CONSOLE LAMPS

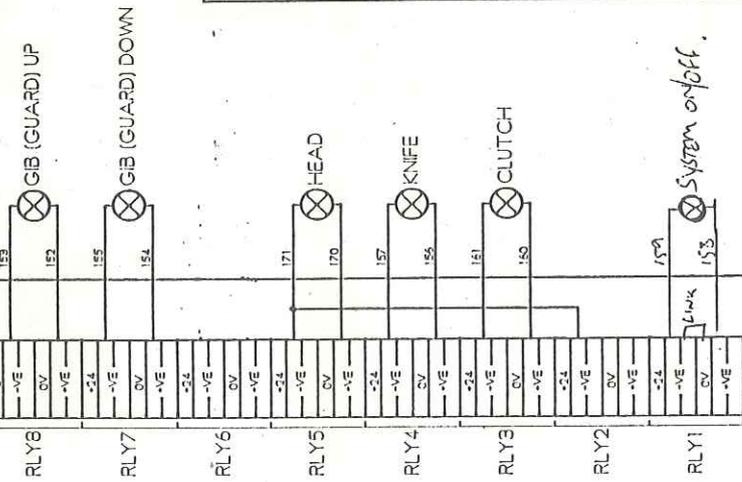

CTM1

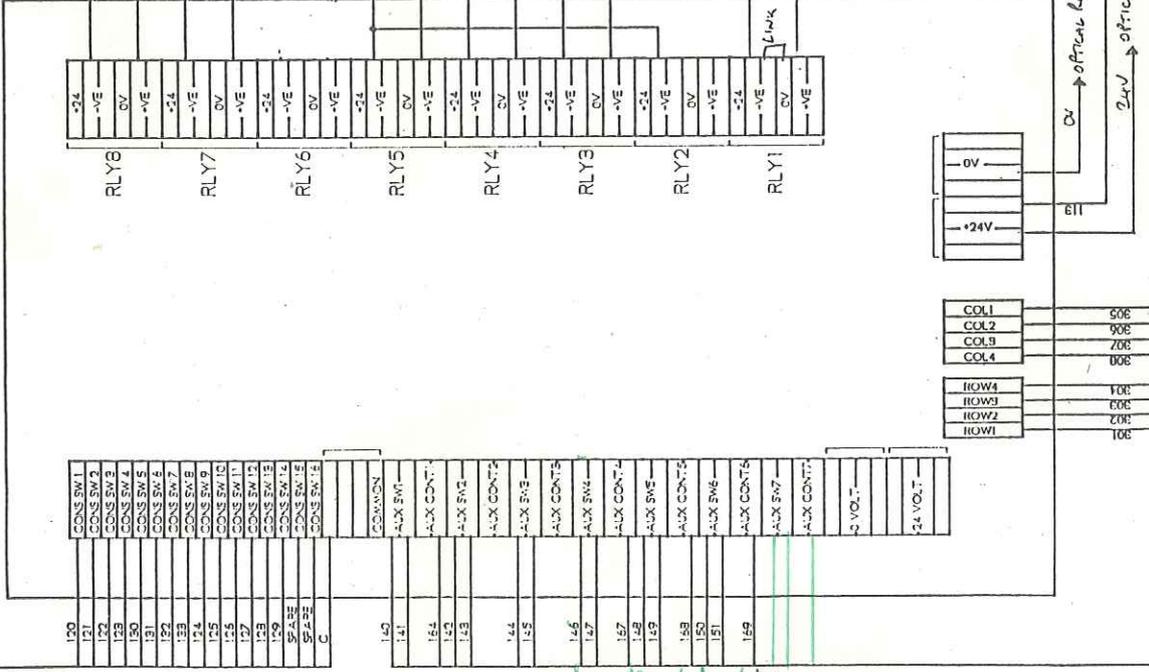


FAN 1
 FAN 2
 FAN 3
 FAN 4
 954
 165

MICA MACHINERY (SALES) LTD
 MICA HOUSE DENTON MANCHESTER
 TEL: 061 320 3356 FAX: 061 320 3345

Lamp e Switch Circuit
 SLITTERS OIF

SCALE NTS
 DATE 3-3-92
 DRG. No B92-70

H40 CON1 - CLUTCH POWER (VERTICAL ONLY)

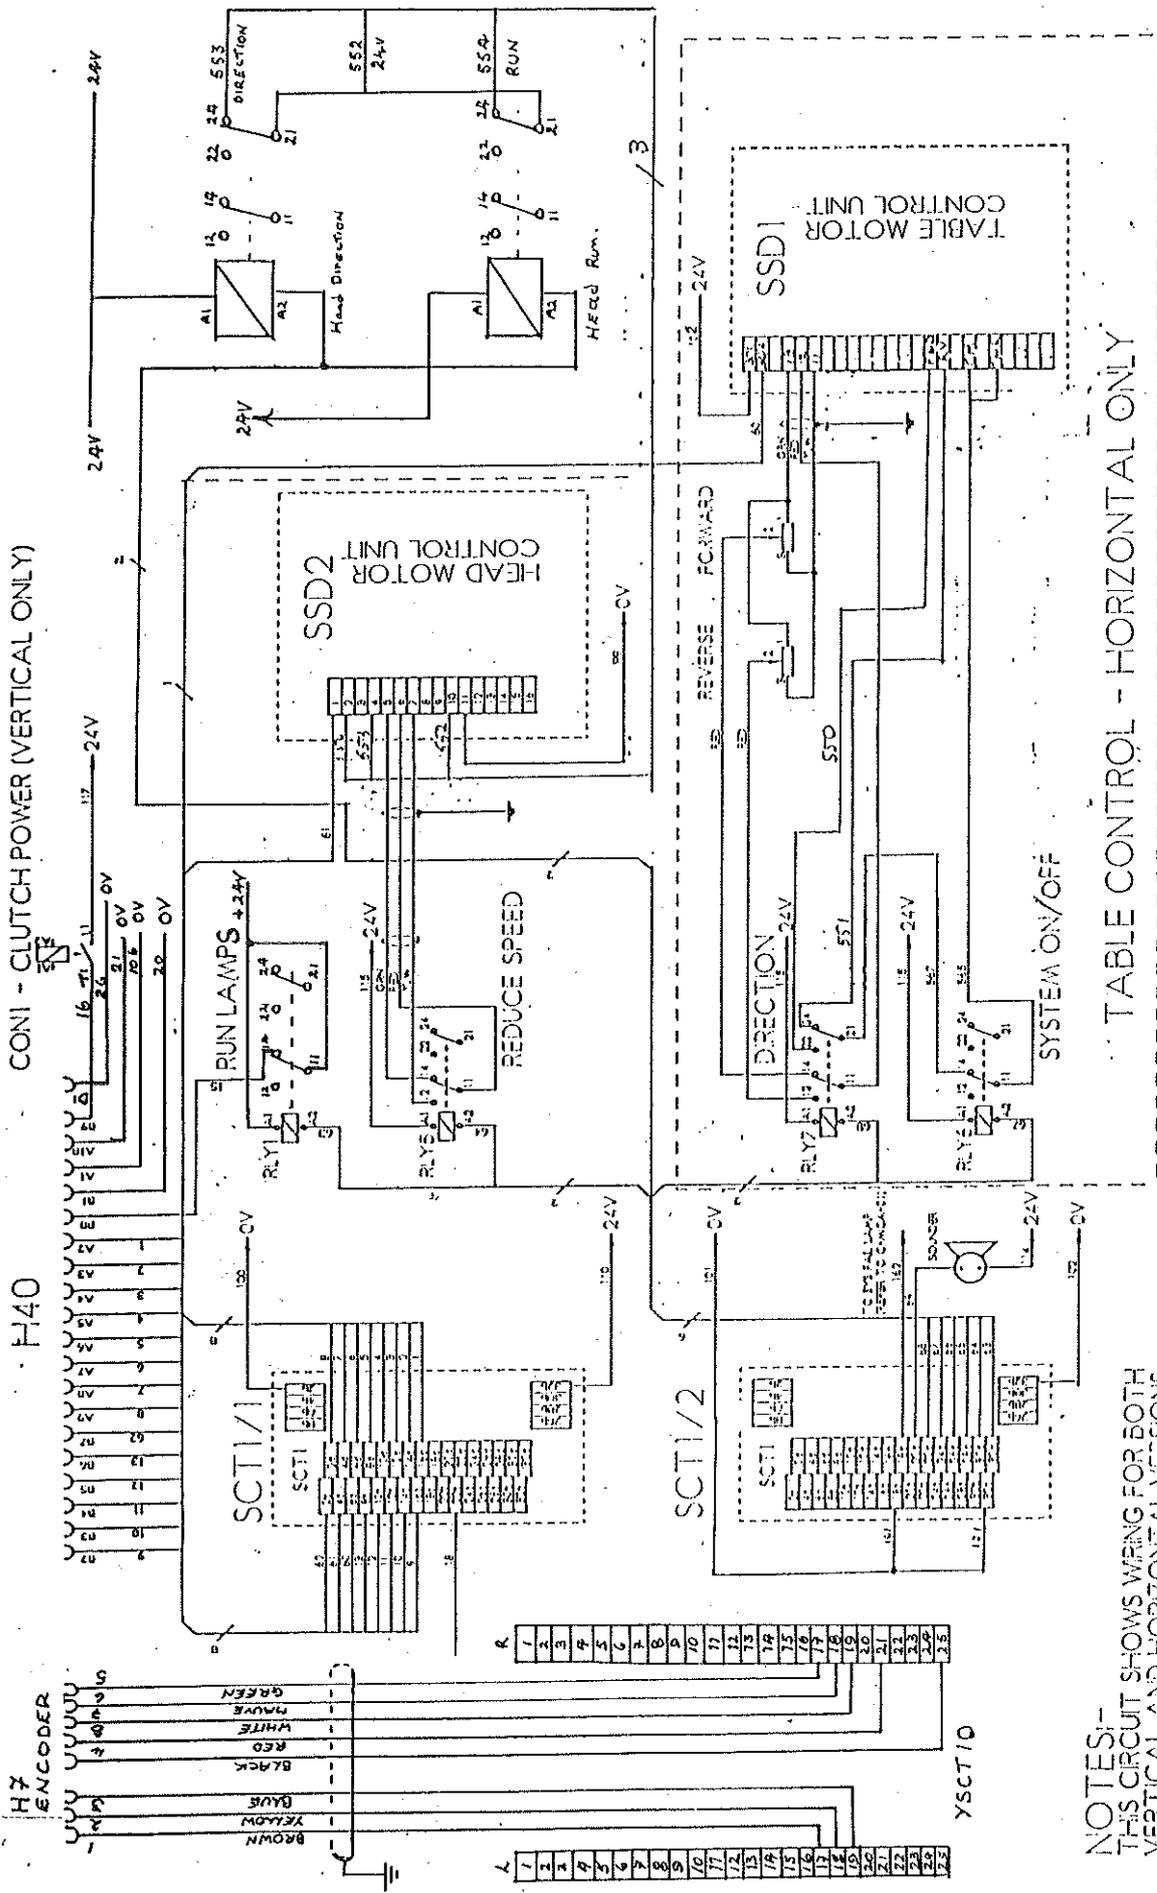


NOTES:-
 THIS CIRCUIT SHOWS WIRING FOR BOTH
 VERTICAL AND HORIZONTAL VERSIONS.
 WIRES 60 / 67 / 68 ARE CONNECTED TO
 THE STEPPER SSD1 FOR VERTICAL AND TO
 THE TABLE SSD1 / RLY6 / RLY7
 FOR HORIZONTAL.

TABLE CONTROL - HORIZONTAL ONLY

REVS	
S.C.T. Control Unit	
SAITTERS	
SCALE NTS.	
DATE 3 - 3 - 92	
DRG. No B92 - 70	

MICA MACHINERY (SALES) LTD
 MICA HOUSE DENTON MANCHESTER
 TEL: 061 320 3356 FAX: 061 320 3345

HEAD LIMITS

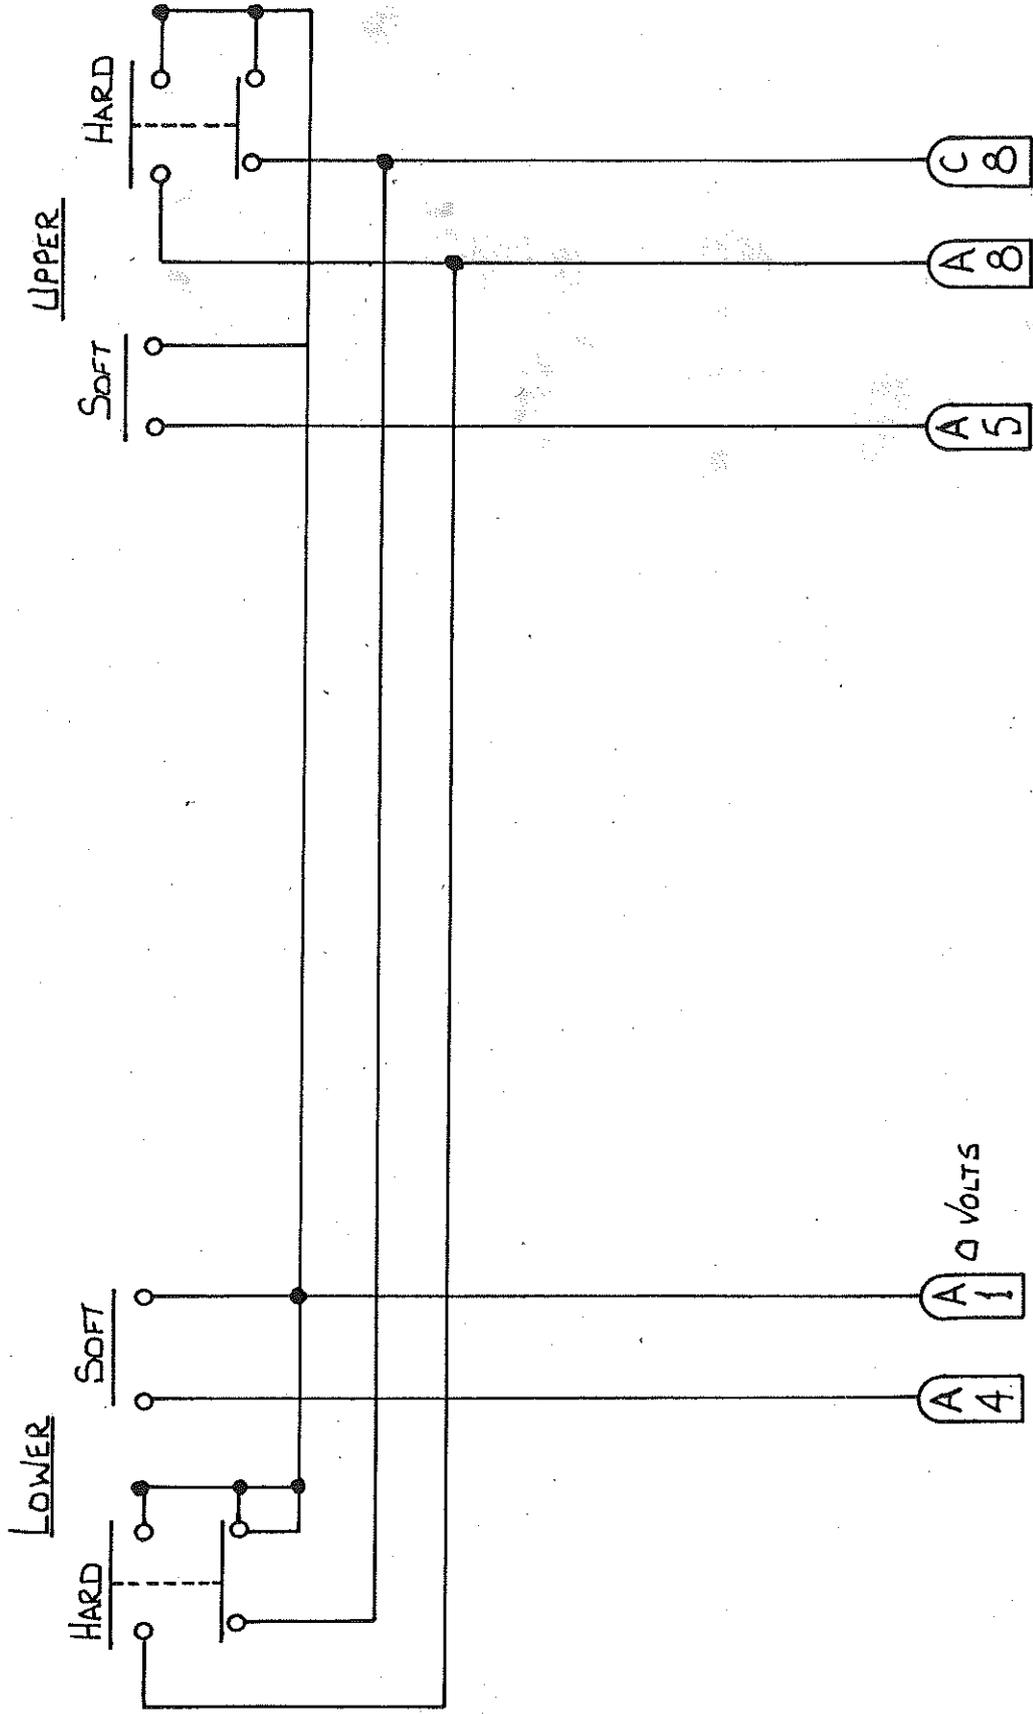

CONNECTION ON H40 PLUG

REVS.					
<u>SC 40 SLITTER</u>			SCALE _____		
<u>ELECTRICAL DETAILS</u>			DATE <u>1-10-90</u>		
			DRG. No <u>A 90-261</u>		
<p>MICA MACHINERY (SALES) LTD MICA HOUSE DENTON MANCHESTER TEL: 061 320 3356 FAX: 061 320 3345</p>					

REVERSE (LEFT).

HARD

SOFT


TABLE LIMITS

TRAVEL

FORWARD (RIGHT).


SOFT

HARD

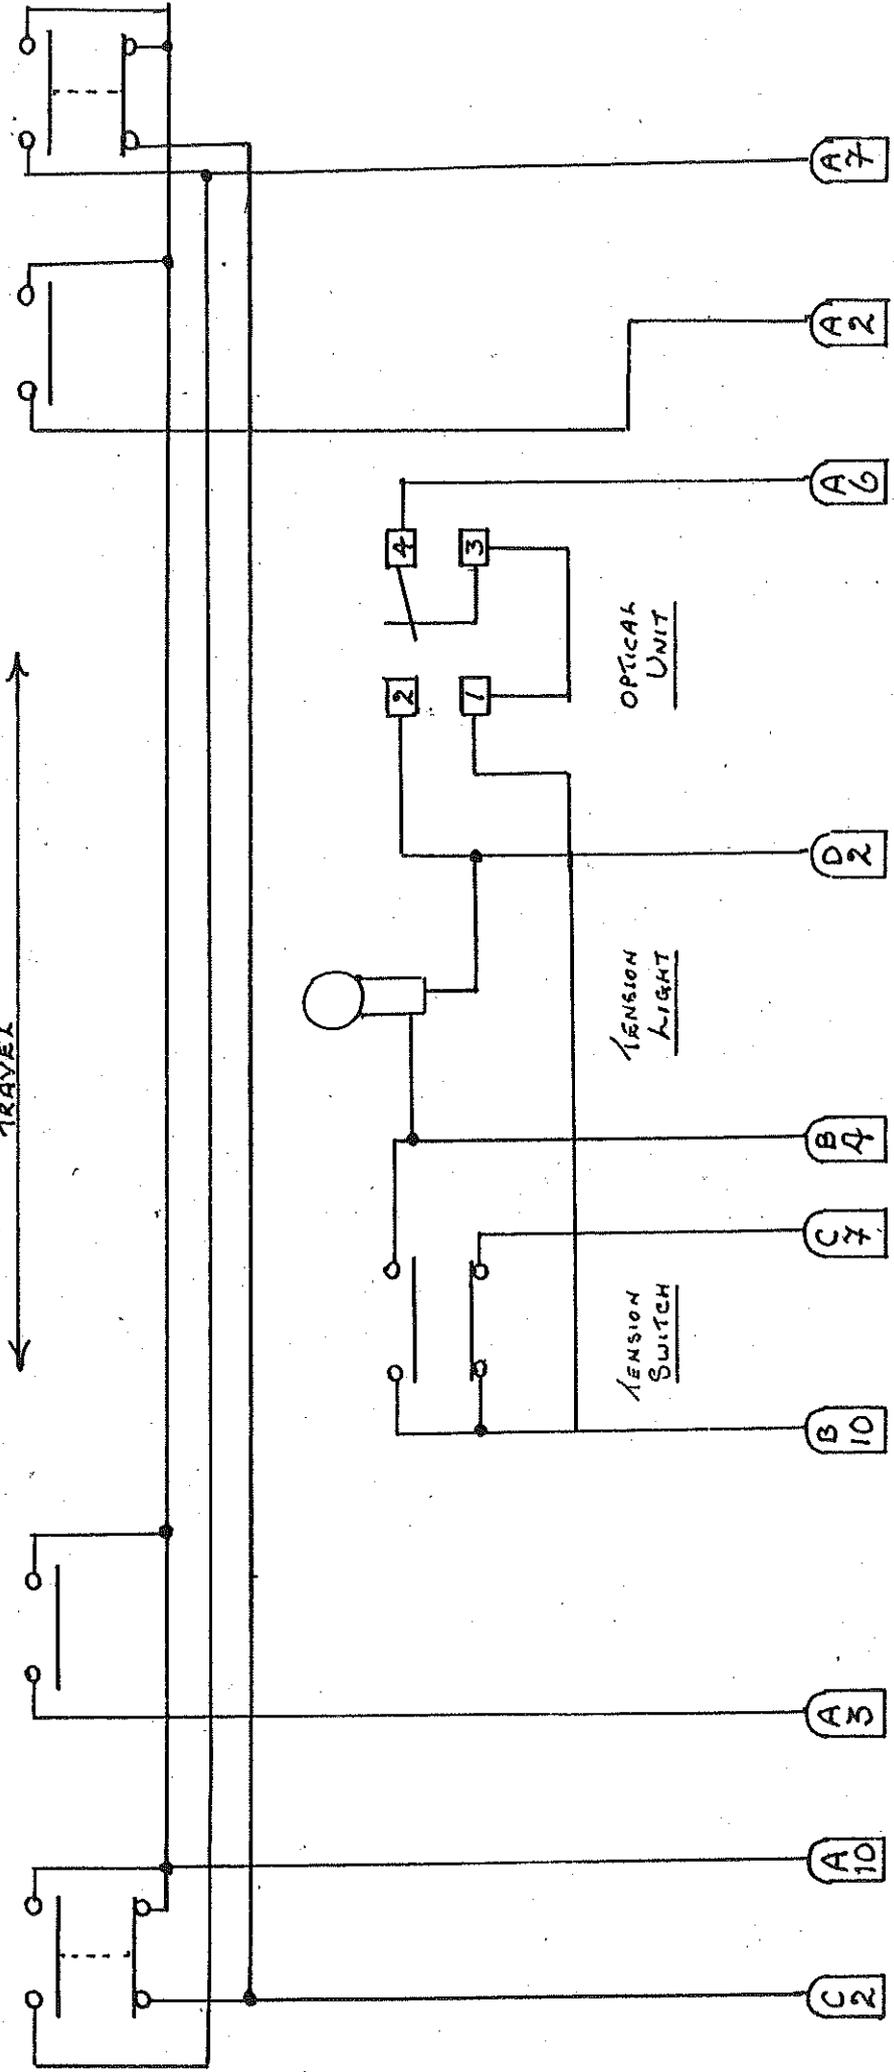


REVS	MICA MACHINERY (SALES) LTD		
	MICA HOUSE DENTON MANCHESTER		
	TEL: 061 320 3356 FAX: 061 320 3345		
	TABLE LIMITS + TENSION UNIT		SCALE N.T.S
	SWITTERS		DATE 3-3-92
	DRG No A90-261		

PRESSURE ROLLER
REMOTE PUSH BUTTONS

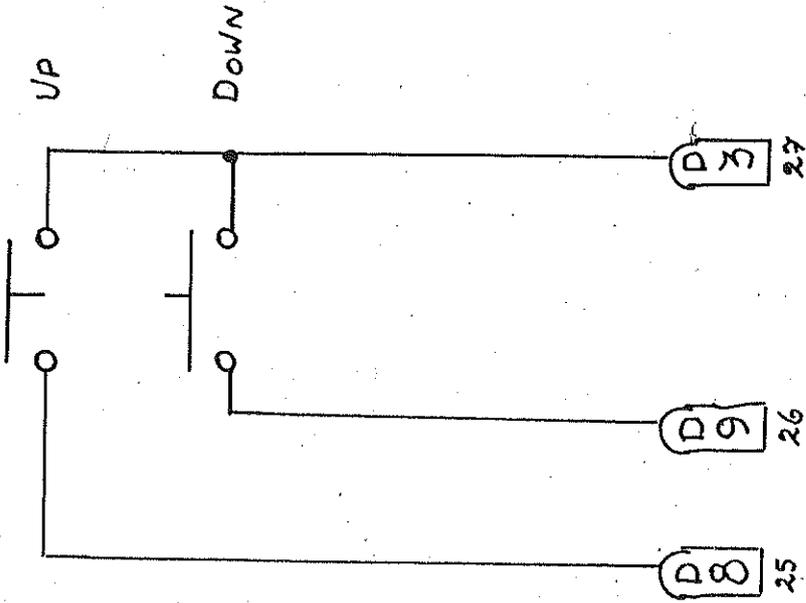


H70 PLUG

PRESSURE ROLLER
LIMIT SWITCHES

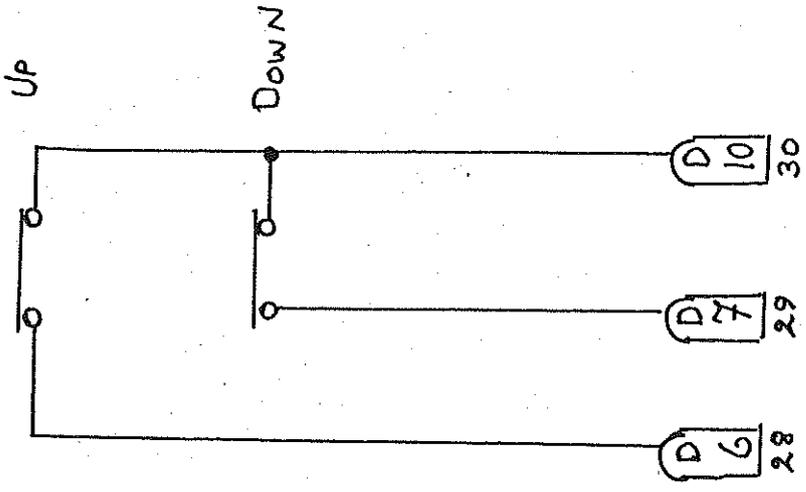

GIB TILT
REMOTE PUSH BUTTONS

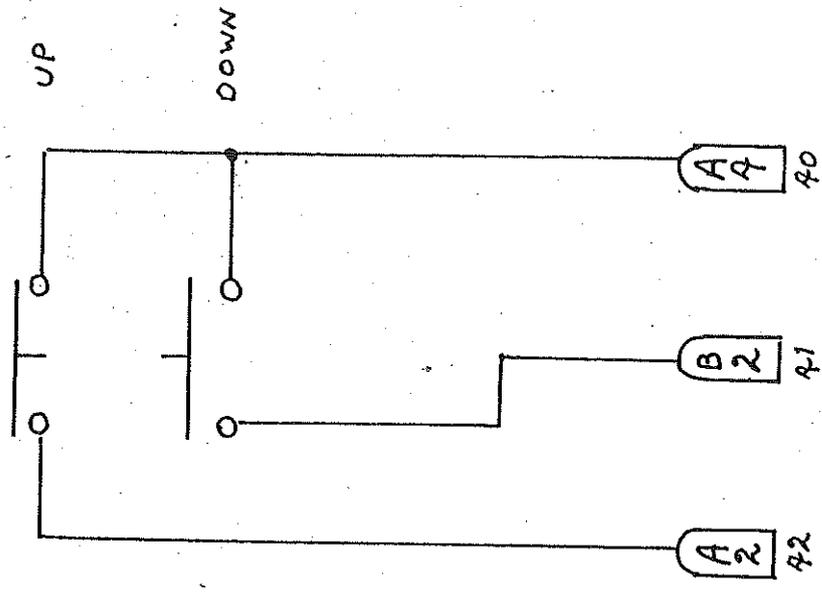

H15 (2) PLUG

REVS	

MICA MACHINERY (SALES) LTD
 MICA HOUSE DENTON MANCHESTER
 TEL: 061 320 3356 FAX: 061 320 3345


REMOTE PUSH BUTTONS • LIMITS
 SLITTERS

SCALE N.T.S.

DATE 3-3-92

DRG. No A90-261

RUNNING LIGHTS

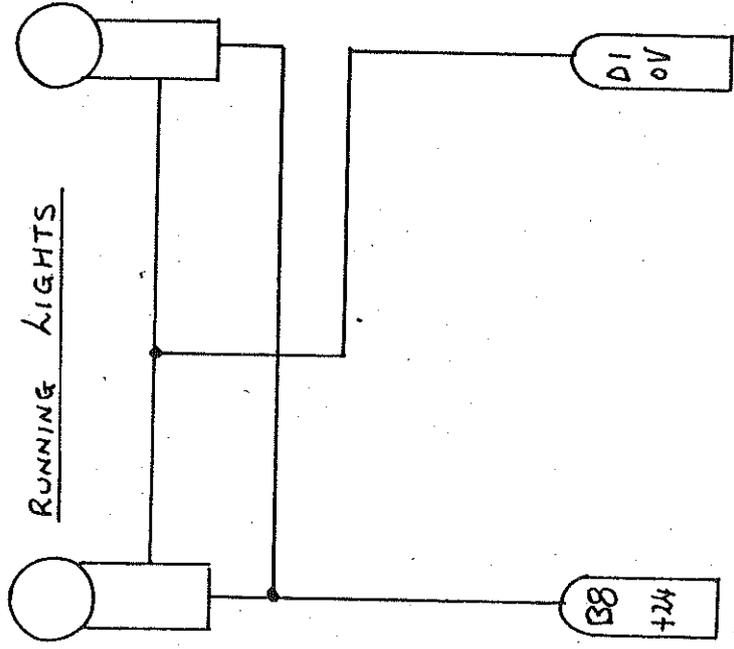

24VOLT 24WATT S.B.C.

H 70 PLUG.

REVS

MICA MACHINERY (SALES) LTD
MICA HOUSE DENTON MANCHESTER
TEL: 061 320 3356 FAX: 061 320 3345

MODIFIED RUN LIGHT CIRCUIT
SWITCHES.

SCALE: N.T.S.
DATE: 3-3-92
DRG No: A92-71